A3
Scaled dimension


This drawing is the copyright of Renewable Connections and must not be reproduced in whole or in part or used in any manner without their written permission.

Scaled dimensions must not be taken from this dawing finensions are to be confirmed on site prior to connect and the confirmed on the prior to connect the confirmed on the prior to connect the confirmed on the prior to connect t

 Revisions:
 Date
 Revision Notes
 Drawn
 Inspected

 01
 10.09.21
 First Issue
 JS
 EP

NOTES:

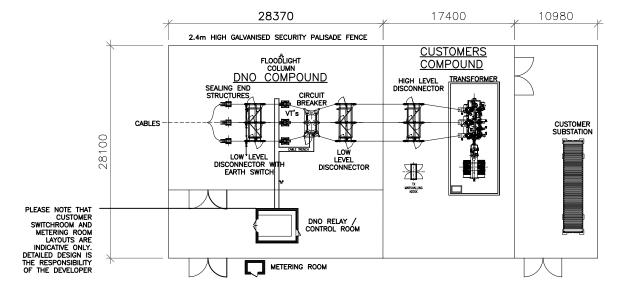



4440 4980 4070

7990 5280


7820

3240

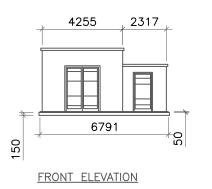

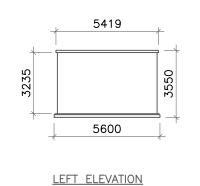

4400 4255

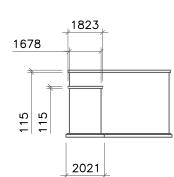

REAR ELEVATION

6573 6900

RIGHT ELEVATION

132kV LOOPED CIRCUIT (UNDERGROUND) PLAN
Scale: 1:500@43

8370

3180

3820

2 CONTROL ROOM AND METER KIOSK ELEVATIONS
Scale: 1:200@A3



**PLANNING** 

3rd Floor, 141 – 145 Curtain Road, London, EC2A 3 Tel: +44 (0)20 7749 2400 enquiries@renewableconpections.co.uk

Drawing Title:
132kV Circuit (Underground) - Plan
Standard Detail

Drawn:

JS

Checked:
EP

Checked:
10.09.2021

Project Code:
Drawing Number:

Project Code: Drawing Number RNC006- SD-15

Sheet Size: Scale: Revision: A3 AN 01

